



-  Flow reducing valve
-  Manual valve
-  Manual valve
-  Reg. valve with I/P positioner
-  On/off valve
-  Valve
-  Centrifugal pump
-  Heat exchanger
-  Instrumentation
-  Steam trap
-  Drain
-  Indicator for interface

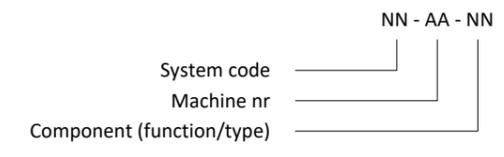

<u>System code</u>	<u>Description</u>	<u>Function/type code</u>	<u>Description</u>
CI	CIP Plant	CT/QT	Conductivity transmitter
DA	Steam	FT	Flow transmitter
		LL	Level low switch
		LH	Level high switch
		LT	Level transmitter
		PT	Pressure transmitter
		TT	Temperature transmitter
<u>MachineNr</u>	<u>Description</u>	V	Valve
03xx	CIP 3	HB	Plate heat exchanger
xx00	Fresh water	P	Centrifugal pumps
xx01	Line 1		
xx02	Line 2		
xx10	Tank 1		
xx20	Tank 2		
xx30	Tank 3		
xx40	Tank 4		
xx50	Tank 5		



								Area Code	Contract No	Drawing title:		Scale
								0300	P18022	CIP 3 Legend		
								System Code	Projection			Format
								CI			A3	
										Document Number:	Sheet	Revision
Rev	Date	Description	Made by	Disc check	Disc appr	Contr appr	Comp appr	20190027-P-XB-0001			1 of 2	

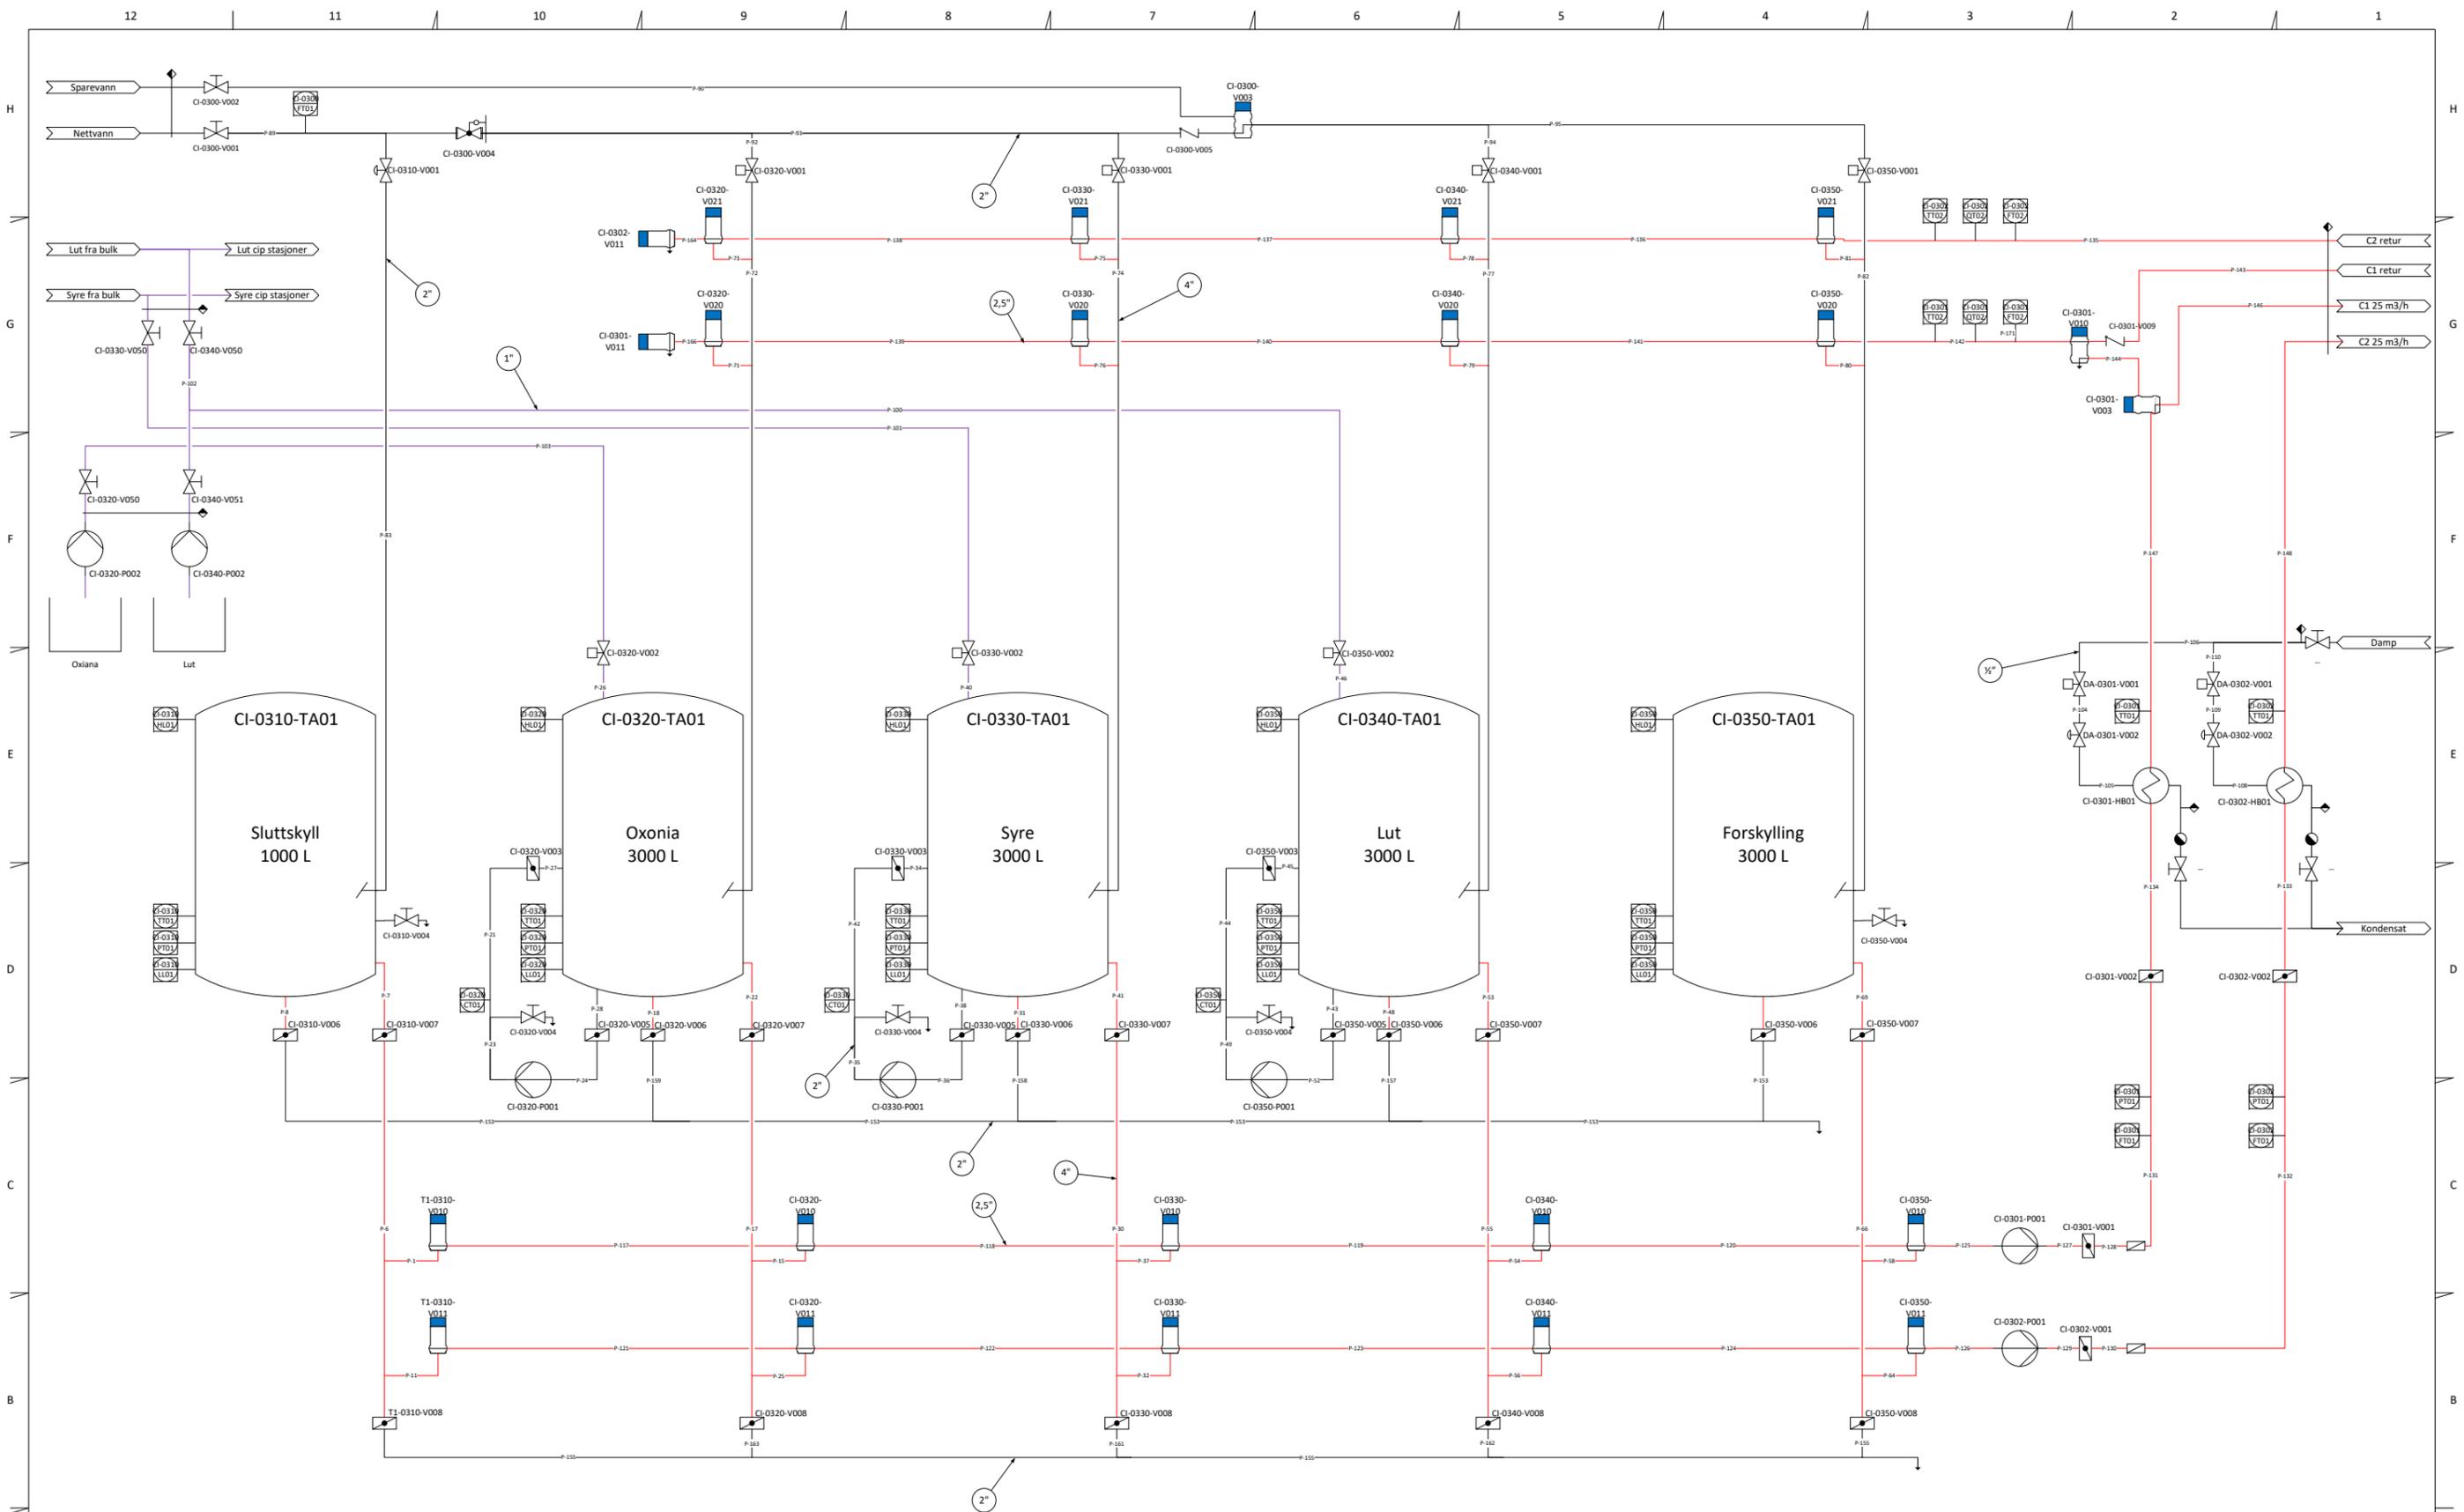

							Area Code	Contract No	Drawing title:		Scale
							0300	P18022	CIP 3		
							System Code	Projection			Format
							CI		P&ID		A3
03	05.06.19	Check valve on C1 return	EAN				Document Number:				Sheet
02	02.05.19	Updated piping and valve size	EAN				20190027-P-XB-0001		2 of 2		
01	18.03.19	Offer	EAN								
Rev	Date	Description	Made by	Disc check	Disc appr	Contr appr	Comp appr				